



N 382,500
E 2,124,500
E 2,125,000
E 2,125,500
E 2,126,000
E 2,126,500

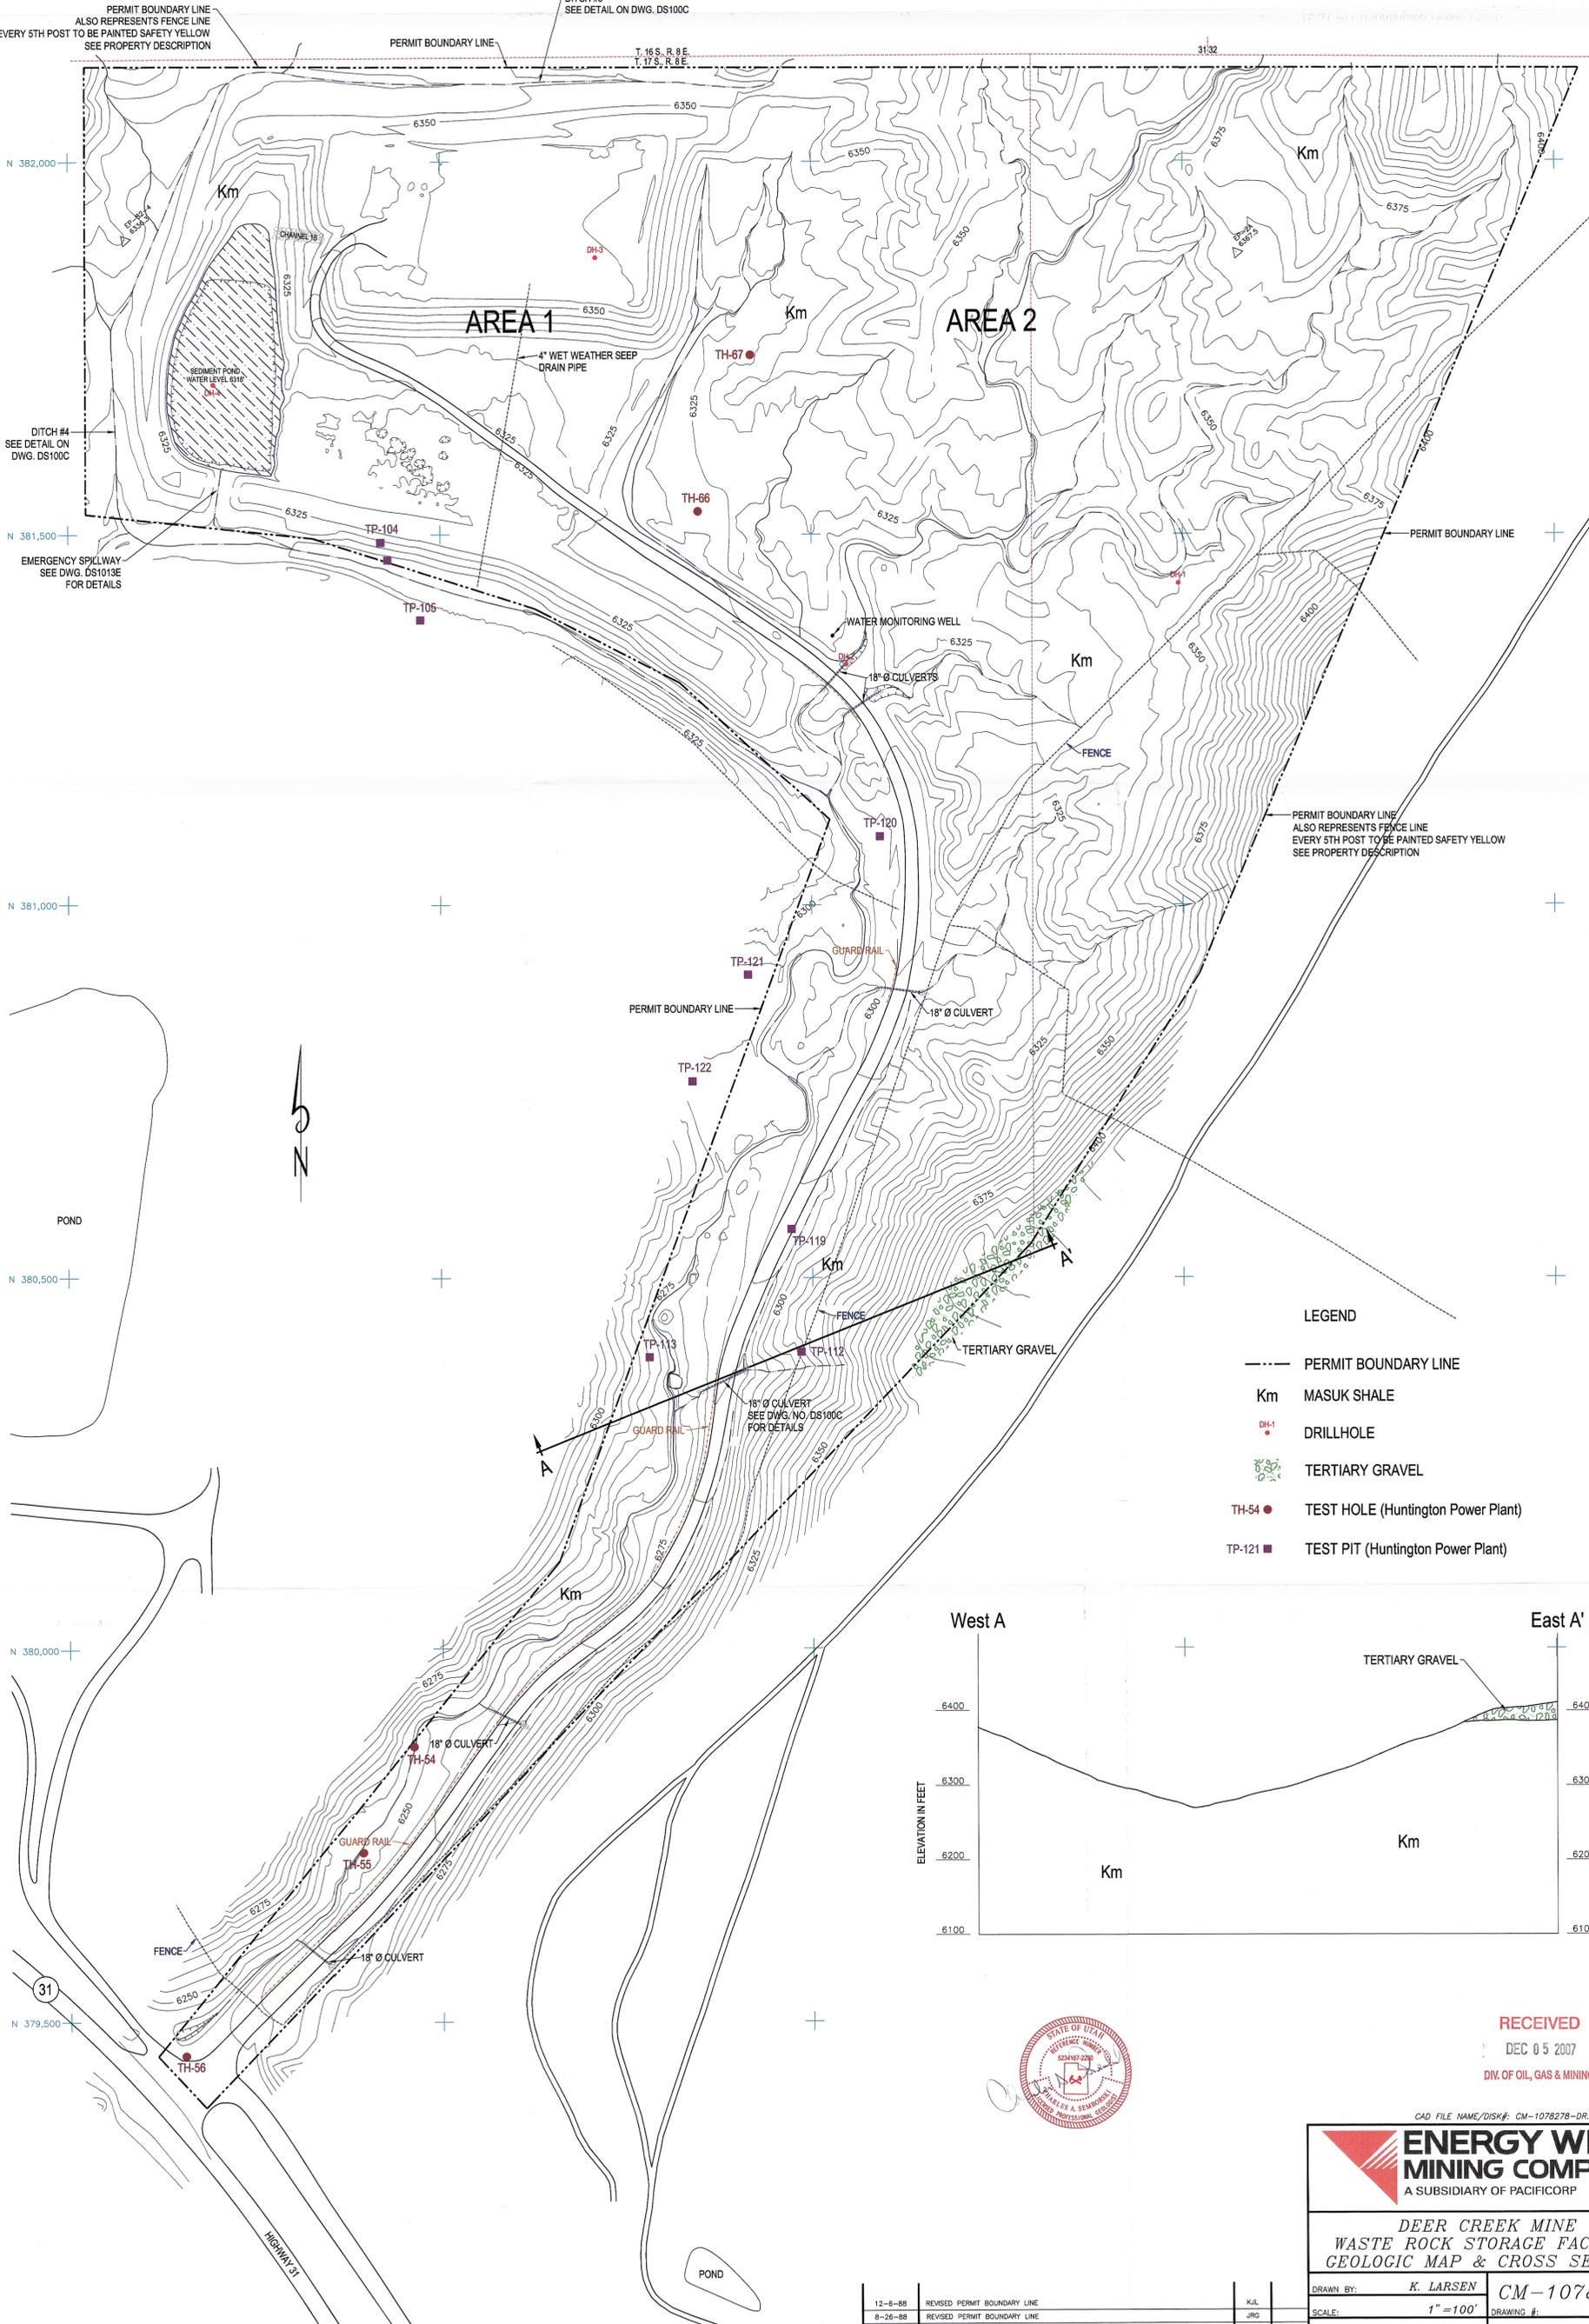

LEGEND

- PERMIT BOUNDARY LINE
- Km MASUK SHALE
- DH-1 DRILLHOLE
- TERTIARY GRAVEL
- TH-54 TEST HOLE (Huntington Power Plant)
- TP-121 TEST PIT (Huntington Power Plant)

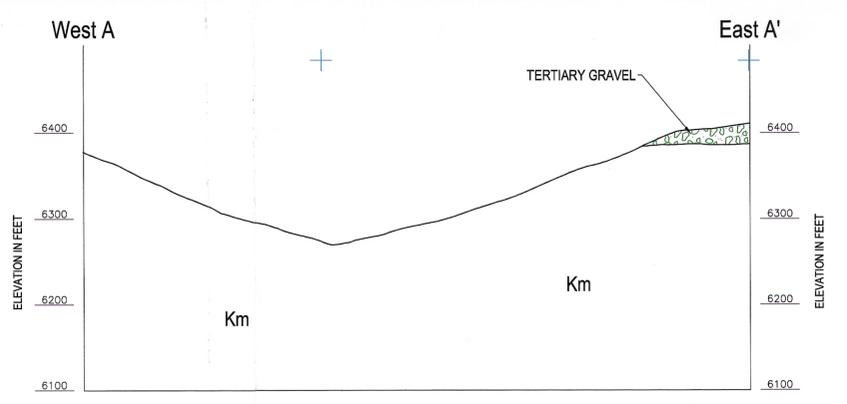

RECEIVED
DEC 05 2007
DIV. OF OIL, GAS & MINING

5-1

CAD FILE NAME/DISK#: CM-1078278-DR.DWG

ENERGY WEST MINING COMPANY
A SUBSIDIARY OF PACIFICORP

DEER CREEK MINE
WASTE ROCK STORAGE FACILITY
GEOLOGIC MAP & CROSS SECTION

DRAWN BY: K. LARSEN
SCALE: 1" = 100'
DATE: MAY 29, 2007

CM-10782-DR
DRAWING #: 1
SHEET 1 OF 1
REV.

DATE	REVISIONS	BY	CHK.
12-6-88	REVISED PERMIT BOUNDARY LINE	K.J.L.	
8-26-88	REVISED PERMIT BOUNDARY LINE	J.R.G.	